



1 LEISURE POOL PLAN  
 1/8" = 1'-0"  
 04/04/08

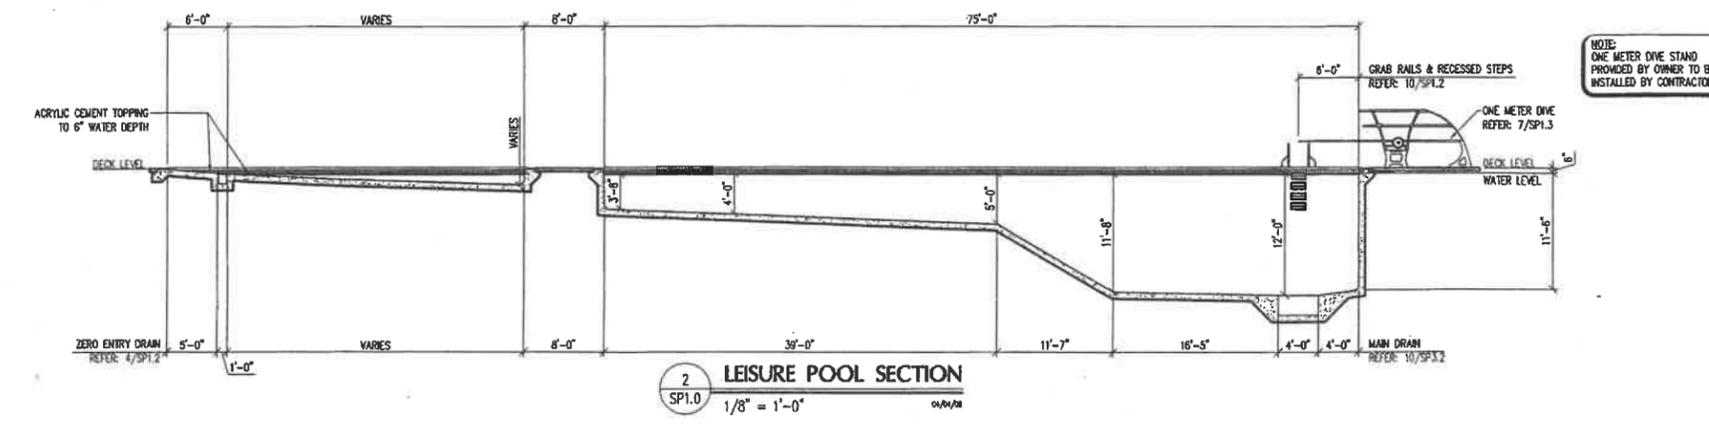

2 LEISURE POOL SECTION  
 1/8" = 1'-0"  
 04/04/08

DEPTH MARKER SCHEDULE	
ID	SIGNAGE
A	0 FT - 0 IN
B	1 FT - 0 IN
C	2 FT - 0 IN
D	3 FT - 0 IN
E	3 FT - 6 IN
F	3 FT - 9 IN
G	5 FT - 0 IN
H	7 FT - 0 IN
J	9 FT - 0 IN
K	11 FT - 0 IN
L	12 FT - 0 IN
Z	NO DIVING OR

POOL EQUIPMENT SCHEDULE		
LEGEND	ID	ITEM
	1	CUP ANCHOR REFER: 1/SP1.2
	2	SAFETY ROPE
	3	GRAB RAIL AND RECESSED STEPS REFER: 10/SP1.2
	4	WEDGE ANCHOR REFER: 11/SP1.2
	5	UNDERWATER LIGHT REFER: 4/SP1.3
	6	RECESSED UNDERWATER LIGHT REFER: 5/SP1.3
	7	MAIN DRAIN FRAME & GRATE REFER: 10/SP3.2
	8	DEEP MAIN DRAIN FRAME & GRATE REFER: 11/SP3.2
	9	POOL LIFT REFER: 6/SP1.3
	10	POOL LIFT ANCHORS REFER: 6/SP1.3
	11	1 METER DIVING BOARD AND MOUNT REFER: 7/SP1.3
	12	STANCHION POST ANCHOR REFER: 12/SP1.3

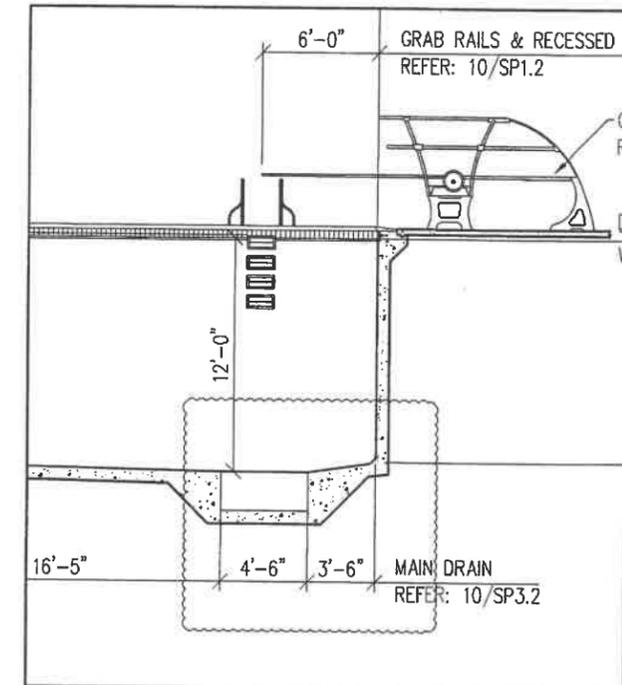

Meade Park  
 Aquatic Center  
 VGB DRAIN MODIFICATIONS



PROJECT MANAGER: DTD	DATE: 07/24/08
DRAWN BY: SHH	SCALE: 1/4" = 1'-0"
CHECKED BY: BAC	
DATE: 07/24/08	


Kimley-Horn  
 and Associates, Inc.  
 250 West Royal Lane, Suite 275  
 Raleigh, North Carolina 27605  
 Tel. No. (314) 432-9900  
 Fax No. (314) 432-9900

**MEADE PARK  
 AQUATIC CENTER  
 CHARLOTTEVILLE, VA**


**LEISURE POOL  
 PLAN & SECTION**

AS SHOWN  
 Designed by: DTB  
 Drawn by: BAC  
 Checked by: EDW  
 Date: AUGUST 2008  
 Project No. 64403400


SHEET  
 SP1.0

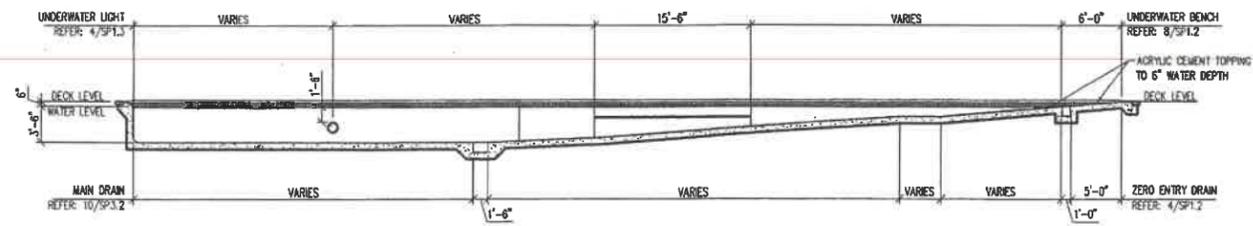


1 LEISURE POOL SECTION  
 SPI.1 1/8" = 1'-0" 04/04/08

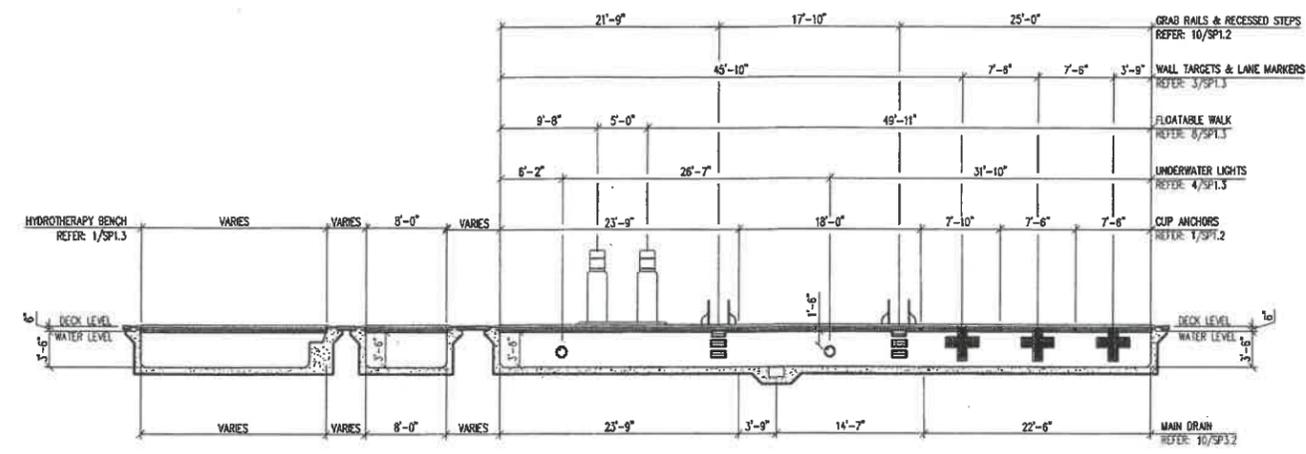


2 LEISURE POOL SECTION  
 SPI.1 1/8" = 1'-0" 04/04/08

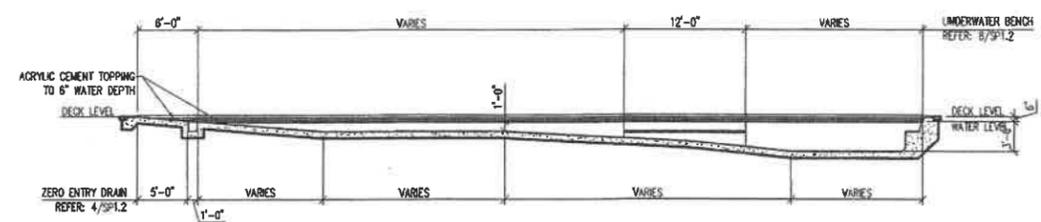

3 LEISURE POOL SECTION  
 SPI.1 1/8" = 1'-0" 04/04/08

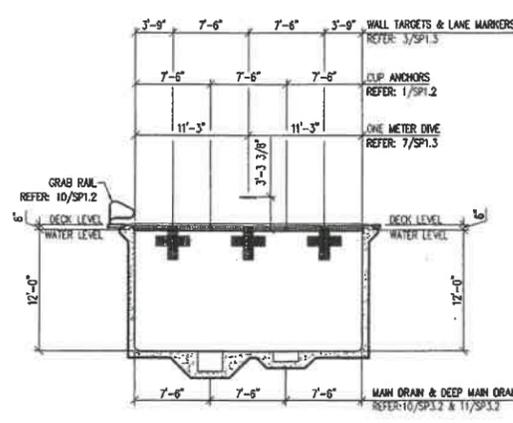

5 LEISURE POOL SECTION  
 SPI.1 1/8" = 1'-0" 04/04/08

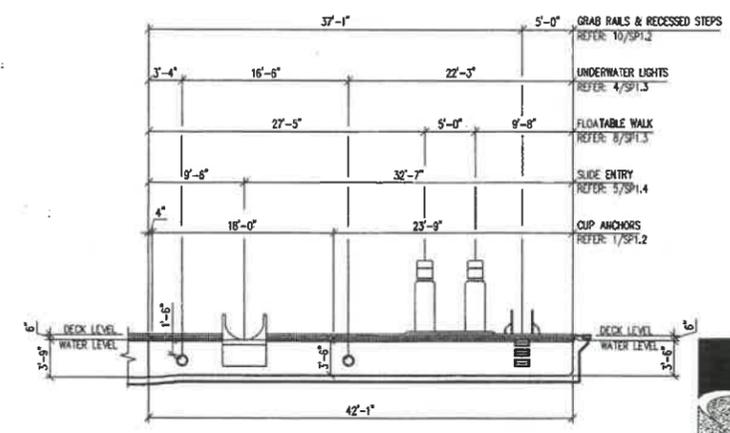

4 LEISURE POOL SECTION  
 SPI.1 1/8" = 1'-0" 04/04/08



No.	Date	Revisions	App.



MEADE PARK  
 AQUATIC CENTER  
 CHARLOTTESVILLE, VA


LEISURE POOL  
 SECTIONS

Scale: AS SHOWN  
 Designed by: DTB  
 Drawn by: BAC  
 Checked by: EDW  
 Date: AUGUST 2008  
 Project No. 64403400


SHEET  
 SP1.1

Kimley-Horn  
 and Associates, Inc.  
 2201 West Regal Lane, Suite 275  
 Irving, Texas 76039  
 Tel. No. (972) 261-5600  
 Fax No. (972) 261-5600


File: W:\Meade Park Pool\SPI.1.dwg (Layout) 8/28/2008 10:08am

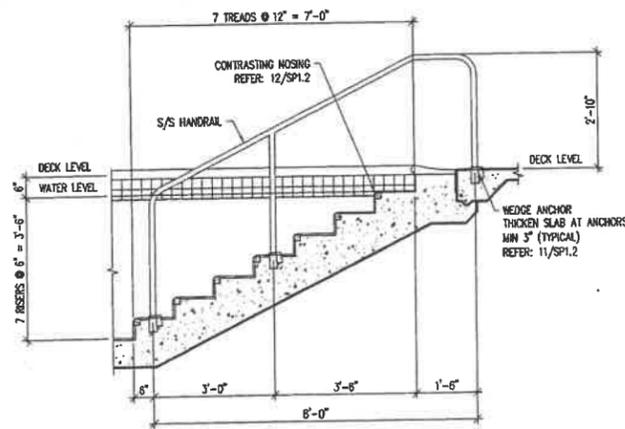


9 STAIR SECTION  
 SPI.2 1/2" = 1'-0"  
 03/15/08

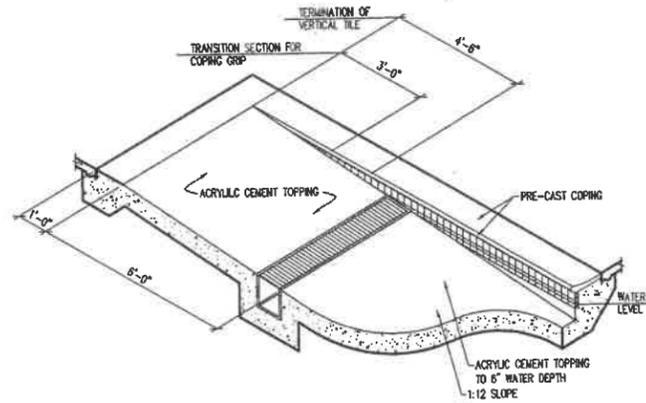


5 ZERO ENTRY SECTION ISOMETRIC  
 SPI.2 3/8" = 1'-0"  
 03/15/08

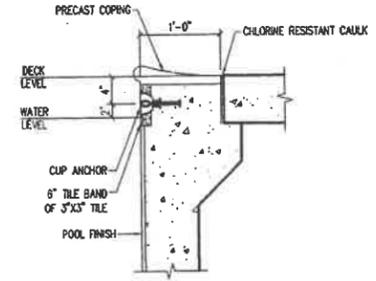


1 POOL WALL SECTION  
 SPI.2 1" = 1'-0"  
 03/15/08

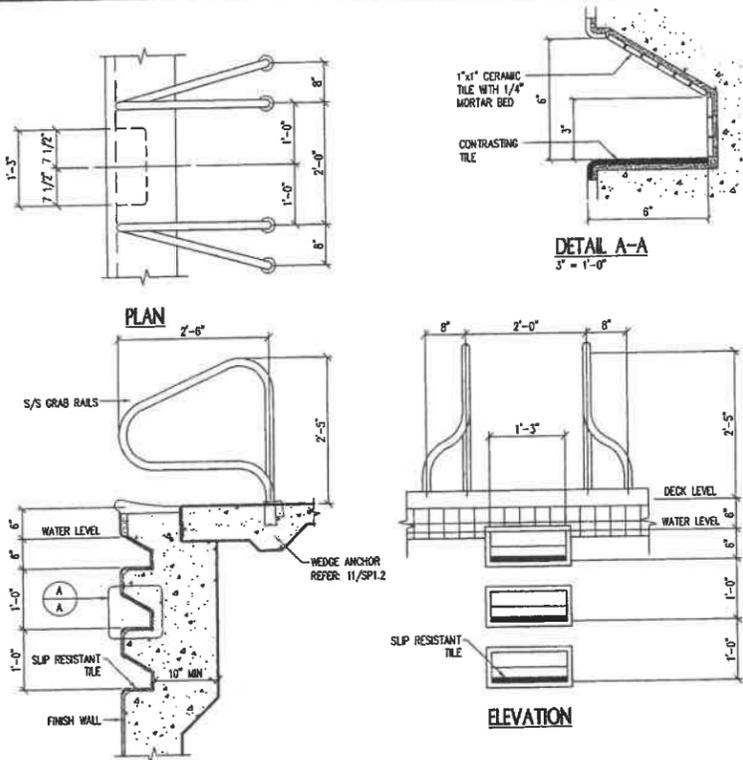


10 GRAB RAILS & RECESSED STEPS  
 SPI.2 3/4" = 1'-0"  
 03/15/08

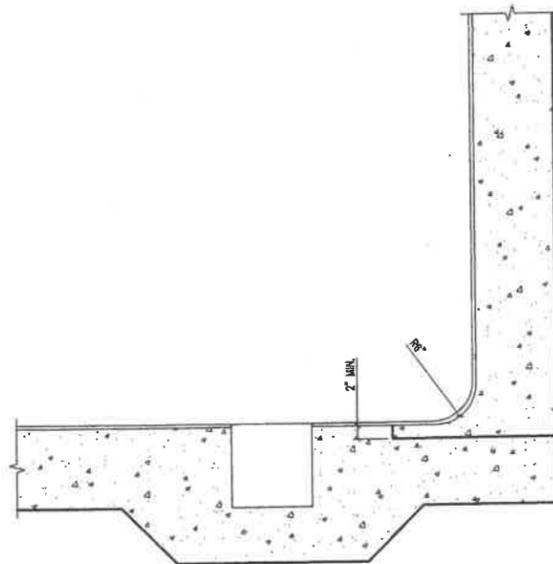


6 PNEUMATICALLY APPLIED CONCRETE COVE  
 SPI.2 1" = 1'-0"  
 03/15/08

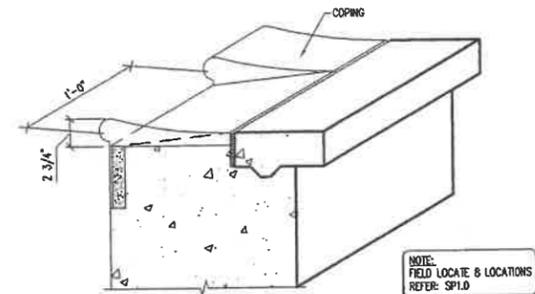


2 RIVERFALL DETAIL  
 SPI.2 1 1/2" = 1'-0"  
 03/15/08

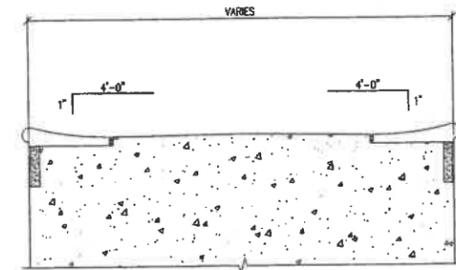


3 CROWN DETAIL  
 SPI.2 1" = 1'-0"  
 03/15/08

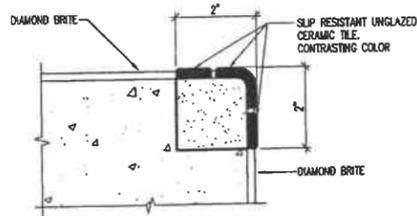


12 CONTRASTING NOSING TILE  
 SPI.2 6" = 1'-0"  
 03/15/08

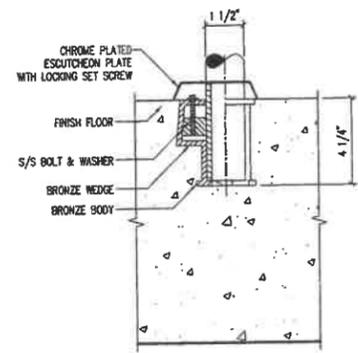


11 WEDGE ANCHOR  
 SPI.2 3" = 1'-0"  
 03/15/08

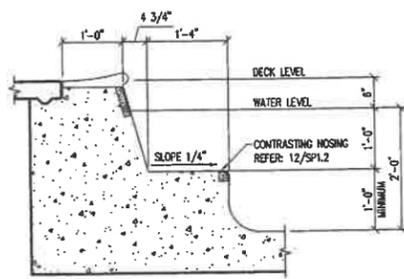

8 UNDERWATER BENCH  
 SPI.2 3/4" = 1'-0"  
 03/15/08

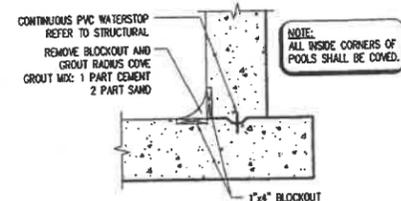

7 CAST IN PLACE CONCRETE COVE  
 SPI.2 3/4" = 1'-0"  
 03/15/08

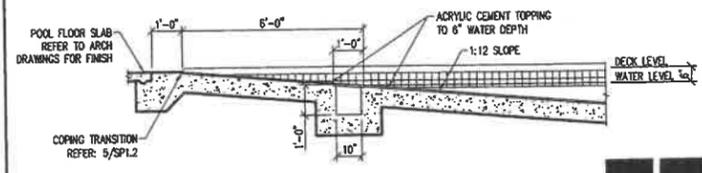

4 ZERO ENTRY SECTION  
 SPI.2 3/8" = 1'-0"  
 03/15/08



Scale: AS SHOWN  
 Designed by: DTB  
 Drawn by: BAC  
 Checked by: EDW  
 Date: AUGUST 2008

SHEET  
 SPI.2



MEADE PARK  
 AQUATIC CENTER  
 CHARLOTTEVILLE, VA

LEISURE POOL  
 DETAILS

Kimley-Horn  
 and Associates, Inc.  
 No. (214) 420-8600  
 Fax No. (214) 420-8600

2201 West Royal Lane, Suite 279  
 Irving, Texas 75063

No.	Date	Revisions	App.